




**MATERIAL LEGEND:**  
 PDC- POWER DISTRIBUTION CENTER  
 PREFABRICATED METAL ENCLOSURE  
 COLOR: TBD

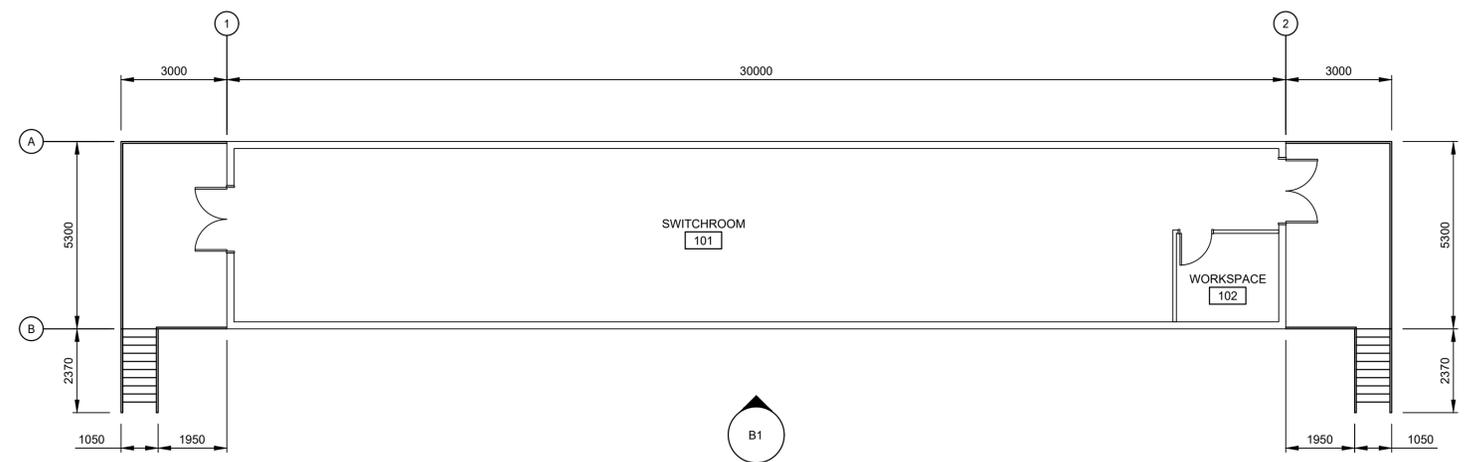


**F1 FLOOR PLAN (TOTAL AREA = 159 SQ. M.)**  
 SCALE: 1:100

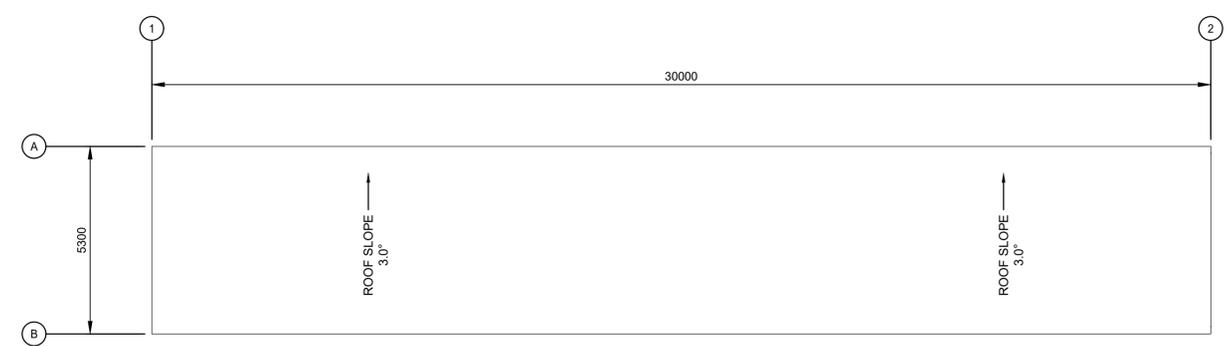

**D1 ROOF PLAN**  
 SCALE: 1:100

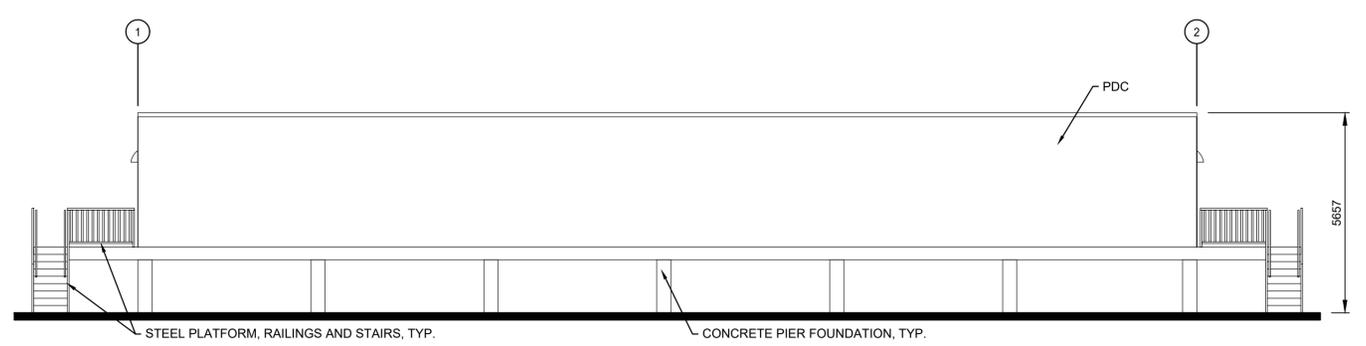

**B1 EAST ELEVATION**  
 SCALE: 1:100

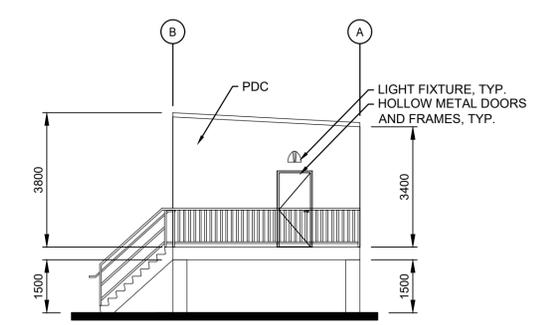

**B7 NORTH ELEVATION**  
 SCALE: 1:100



MARK	DESCRIPTION	DATE
C	RE-ISSUED FOR 30% REVIEW	21JUL25
B	RE-ISSUED FOR 30% REVIEW	14JUL25
A	ISSUED FOR 30% REVIEW	23JUN25

DESIGNED BY:	ISSUE DATE:
AR	23JUN25
DRAWN BY:	SOLICITATION NO.:
AR	
CHECKED BY:	CONTRACT NO.:
SR	
SUBMITTED BY:	
BEG	
SIZE:	
ISO A1	

PINEHURST  
 WALES, UK

RADAR COMPLEX AND SUPPORT CAMPUS DESIGN

SWITCHROOM BUILDING (SRB)  
 PLANS & ELEVATIONS

SHEET ID  
**SRB**  
**A-151**